



ELECTRICAL SITE PLAN
SCALE: 1" = 20'-0"

 
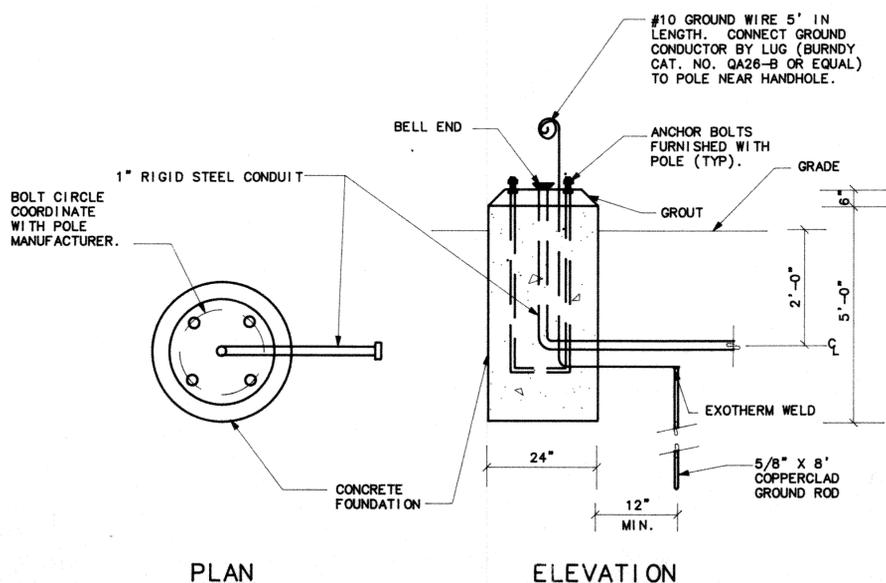


PLAN
ELEVATION
POLE FOUNDATION DETAIL
SCALE: NONE

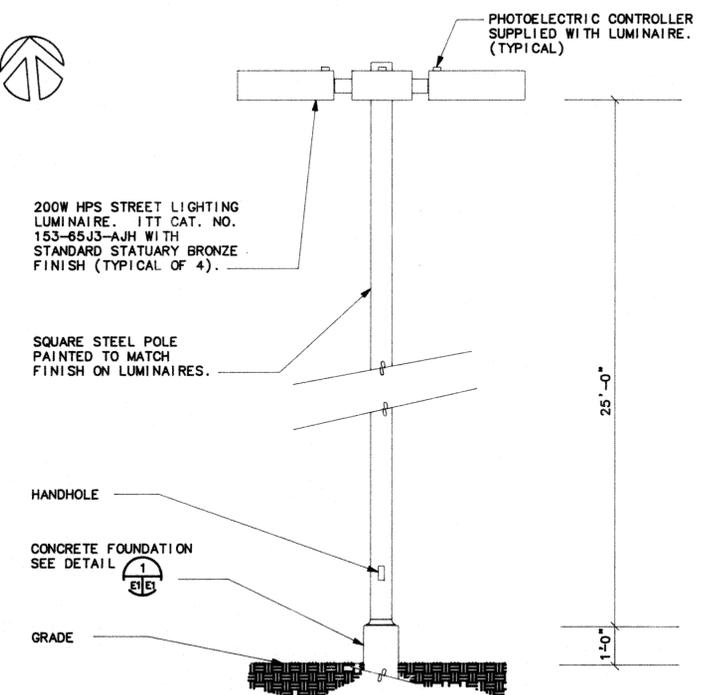

LUMINAIRE MOUNTING DETAIL
SCALE: NONE

- ELECTRICAL SYMBOLS**
- GENERAL**
LIGHT LINE INDICATES EXISTING WORK OR BACKGROUND
HEAVY LINE INDICATES NEW WORK
- DETAIL IDENTIFICATION**
NUMBER INDICATES DETAIL
SHEET NUMBER WHERE DETAIL IS DRAWN
SHEET NUMBER WHERE DETAIL IS TAKEN
- EXISTING**
EXISTING RACEWAY
EXISTING EQUIPMENT AS INDICATED
- EXISTING TO BE REMOVED**
EXISTING RACEWAY TO BE REMOVED
EXISTING EQUIPMENT TO BE REMOVED
- FIXTURES**
FIXTURE TYPE SEE SCHEDULE
RECESSED FLUORESCENT FIXTURE
SURFACE/PENDANT MOUNTED FLUORESCENT FIXTURE
CEILING MOUNTED FIXTURE
CEILING MOUNTED FIXTURE WITH QUARTZ RESTRIKE
WALL MOUNTED FIXTURE
WALL MOUNTED EXIT SIGN (TYPE X)
- SWITCHES**
SINGLE POLE SWITCH
THREE-WAY SWITCH
- RECEPTACLES**
DUPLEX RECEPTACLE, 20A/120V
DUPLEX RECEPTACLE, GROUND FAULT CIRCUIT INTERRUPTING
RECEPTACLE WITH WEATHER-PROOF COVER, (TYPE AS INDICATED ABOVE)
- POWER**
PANEL BOARD 208/120V
PANEL BOARD 480/277V
CABINET
NON-FUSED DISCONNECT SWITCH, 30A UNLESS OTHERWISE INDICATED, [WP-NEMA 3R WHERE INDICATED]
FUSED DISCONNECT SWITCH (200A SWITCH WITH 175A FUSE)
MOTOR CONNECTION, SIZE AND VOLTAGE AS INDICATED
EQUIPMENT CONNECTION
CIRCUIT BREAKER
MANUAL MOTOR STARTER (SWITCH WITH OVERLOAD, PILOT LIGHT, AND COVER PLATE)
- MISCELLANEOUS**
JUNCTION BOX
EQUIPMENT DESIGNATOR
- RACEWAYS**
RACEWAY CONCEALED, EXPOSED IN UNFINISHED AREAS
RACEWAY CONCEALED IN OR BELOW FLOOR
SURFACE METAL RACEWAY
BRANCH CIRCUIT WIRING SHOWING CIRCUIT HOME RUN TO PANELBOARD, (HASH MARKS SHOW NO. OF WIRES WHEN MORE THAN TWO REQD., NEUTRAL SHOWN LONGER) DOT INDICATES GROUND WIRE
RACEWAY TURNING UP
RACEWAY TURNING DOWN
- SIGNAL/COMMUNICATION**
TELEPHONE OUTLET
- ABBREVIATIONS**
A, E, EXIST
KVA
NTS
PHL
V
W
EQUIP
GND
XFMR
DISC
- AMPERE
EXISTING
KILOVOLTAMPERES
NOT TO SCALE
PHASE
PANEL
VOLTS
WATT, WIRE
EQUIPMENT
GROUND
TRANSFORMER
DISCONNECT

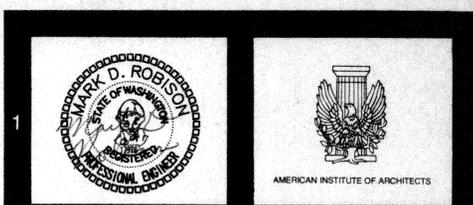

HAL MOE POOL ENCLOSURE

SITE PLAN

THE TSANG PARTNERSHIP, INC.

1221 SECOND AVENUE, SUITE 300, SEATTLE, WA 98101
748 MARKET STREET, SUITE 200, TACOMA, WA 98402
(206) 340-9044 (206) 272-8383
FAX (206) 884-8699 FAX (206) 392-8299

8-7-89
DATE:

REVISED: E1
SHEET NO.: